


TAG	DESCRIPTION	LUMENS	WATTS
S1	WDGE2 LED P2 40K 80CRI TFTM	2030	18.9815
S2	WDGE4 LED P3 70CRI RFT 40K	18326	124.86
S3	WDGE3 LED P2 70CRI R2 40K	8663	59.2761
S4	RSX3 LED P3 40K R5	36282	266.82

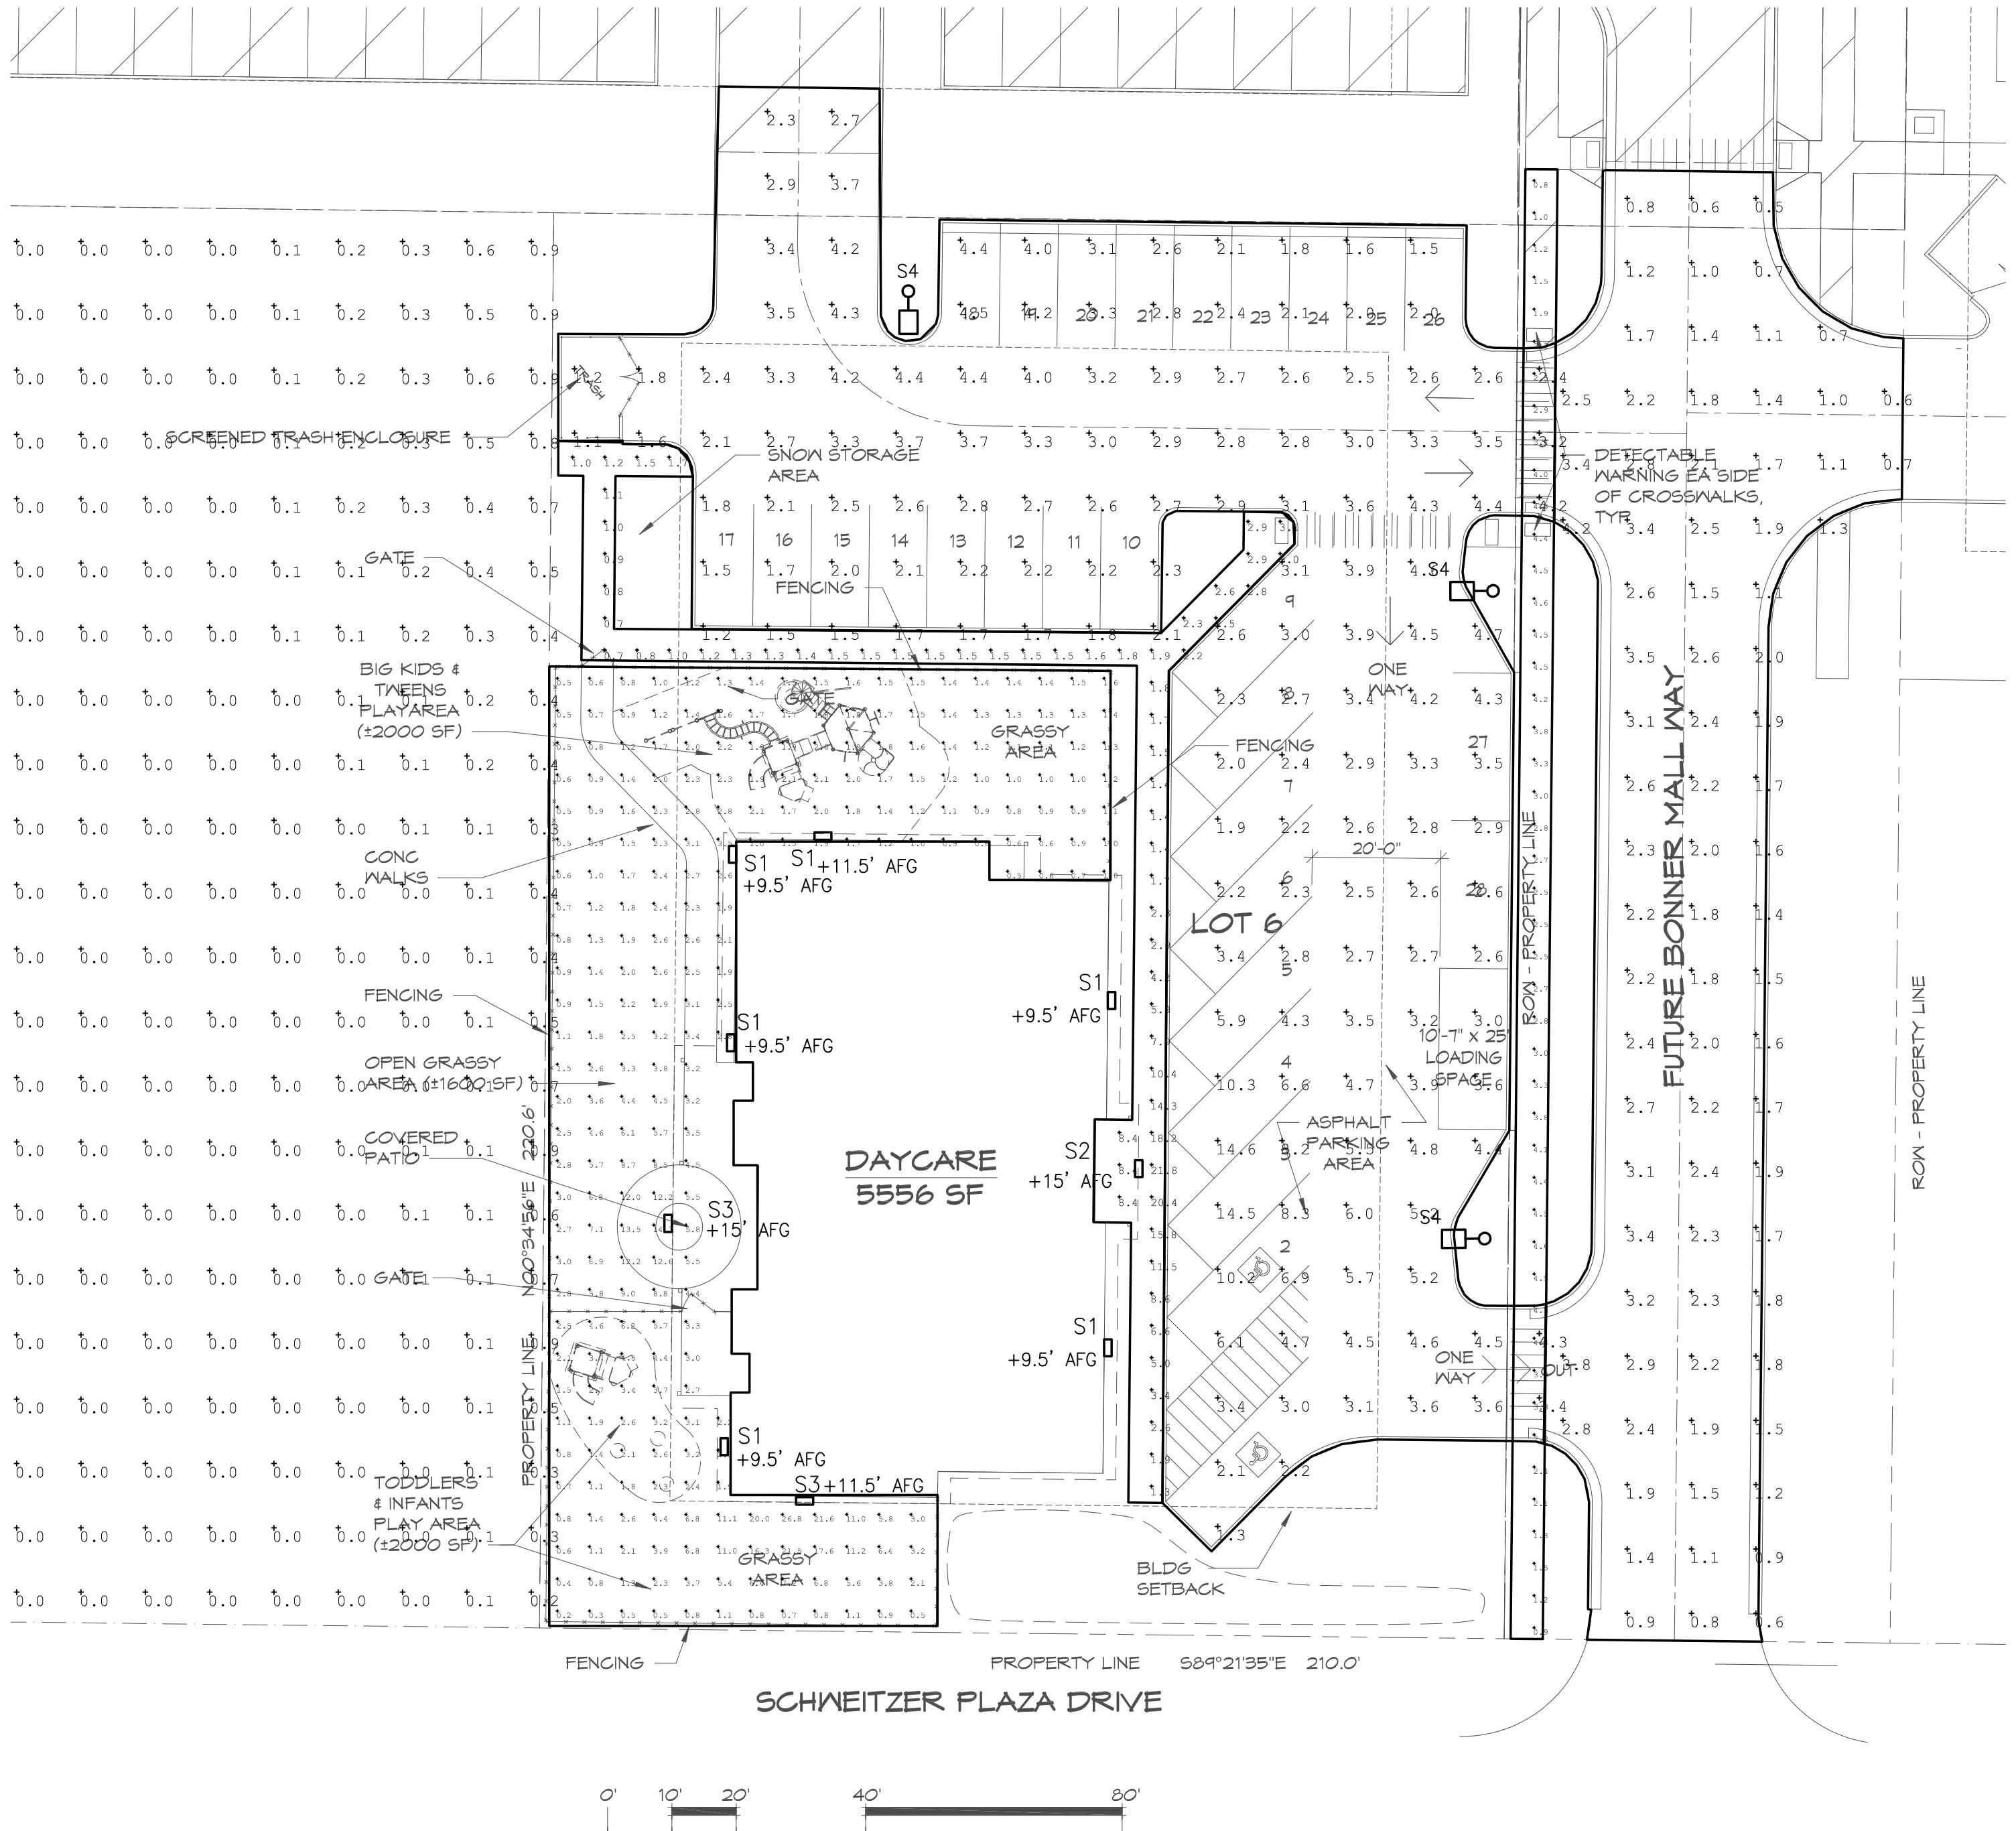

ELECTRICAL SITE PLAN - PHOTOMETRICS

PROJECT/TITLE

SEAL

06/28/2022

PROJECT NO.

2134.01

DRAWN:

JPB

CHECKED:

JDN

DATE:

07/14/22

DRAWING NO.

M103